
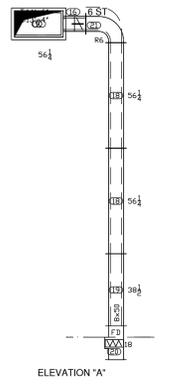
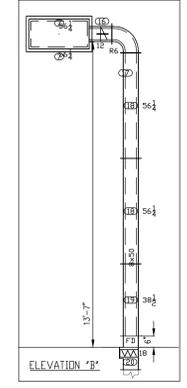
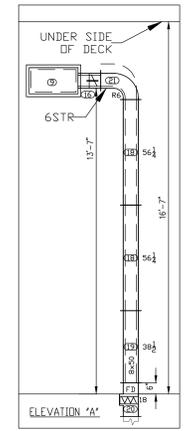
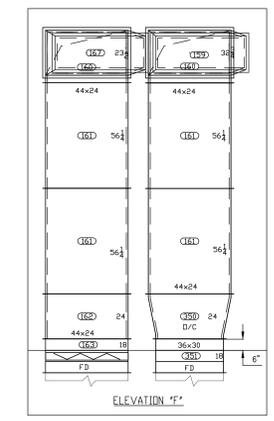


DWG 302
DWG 301

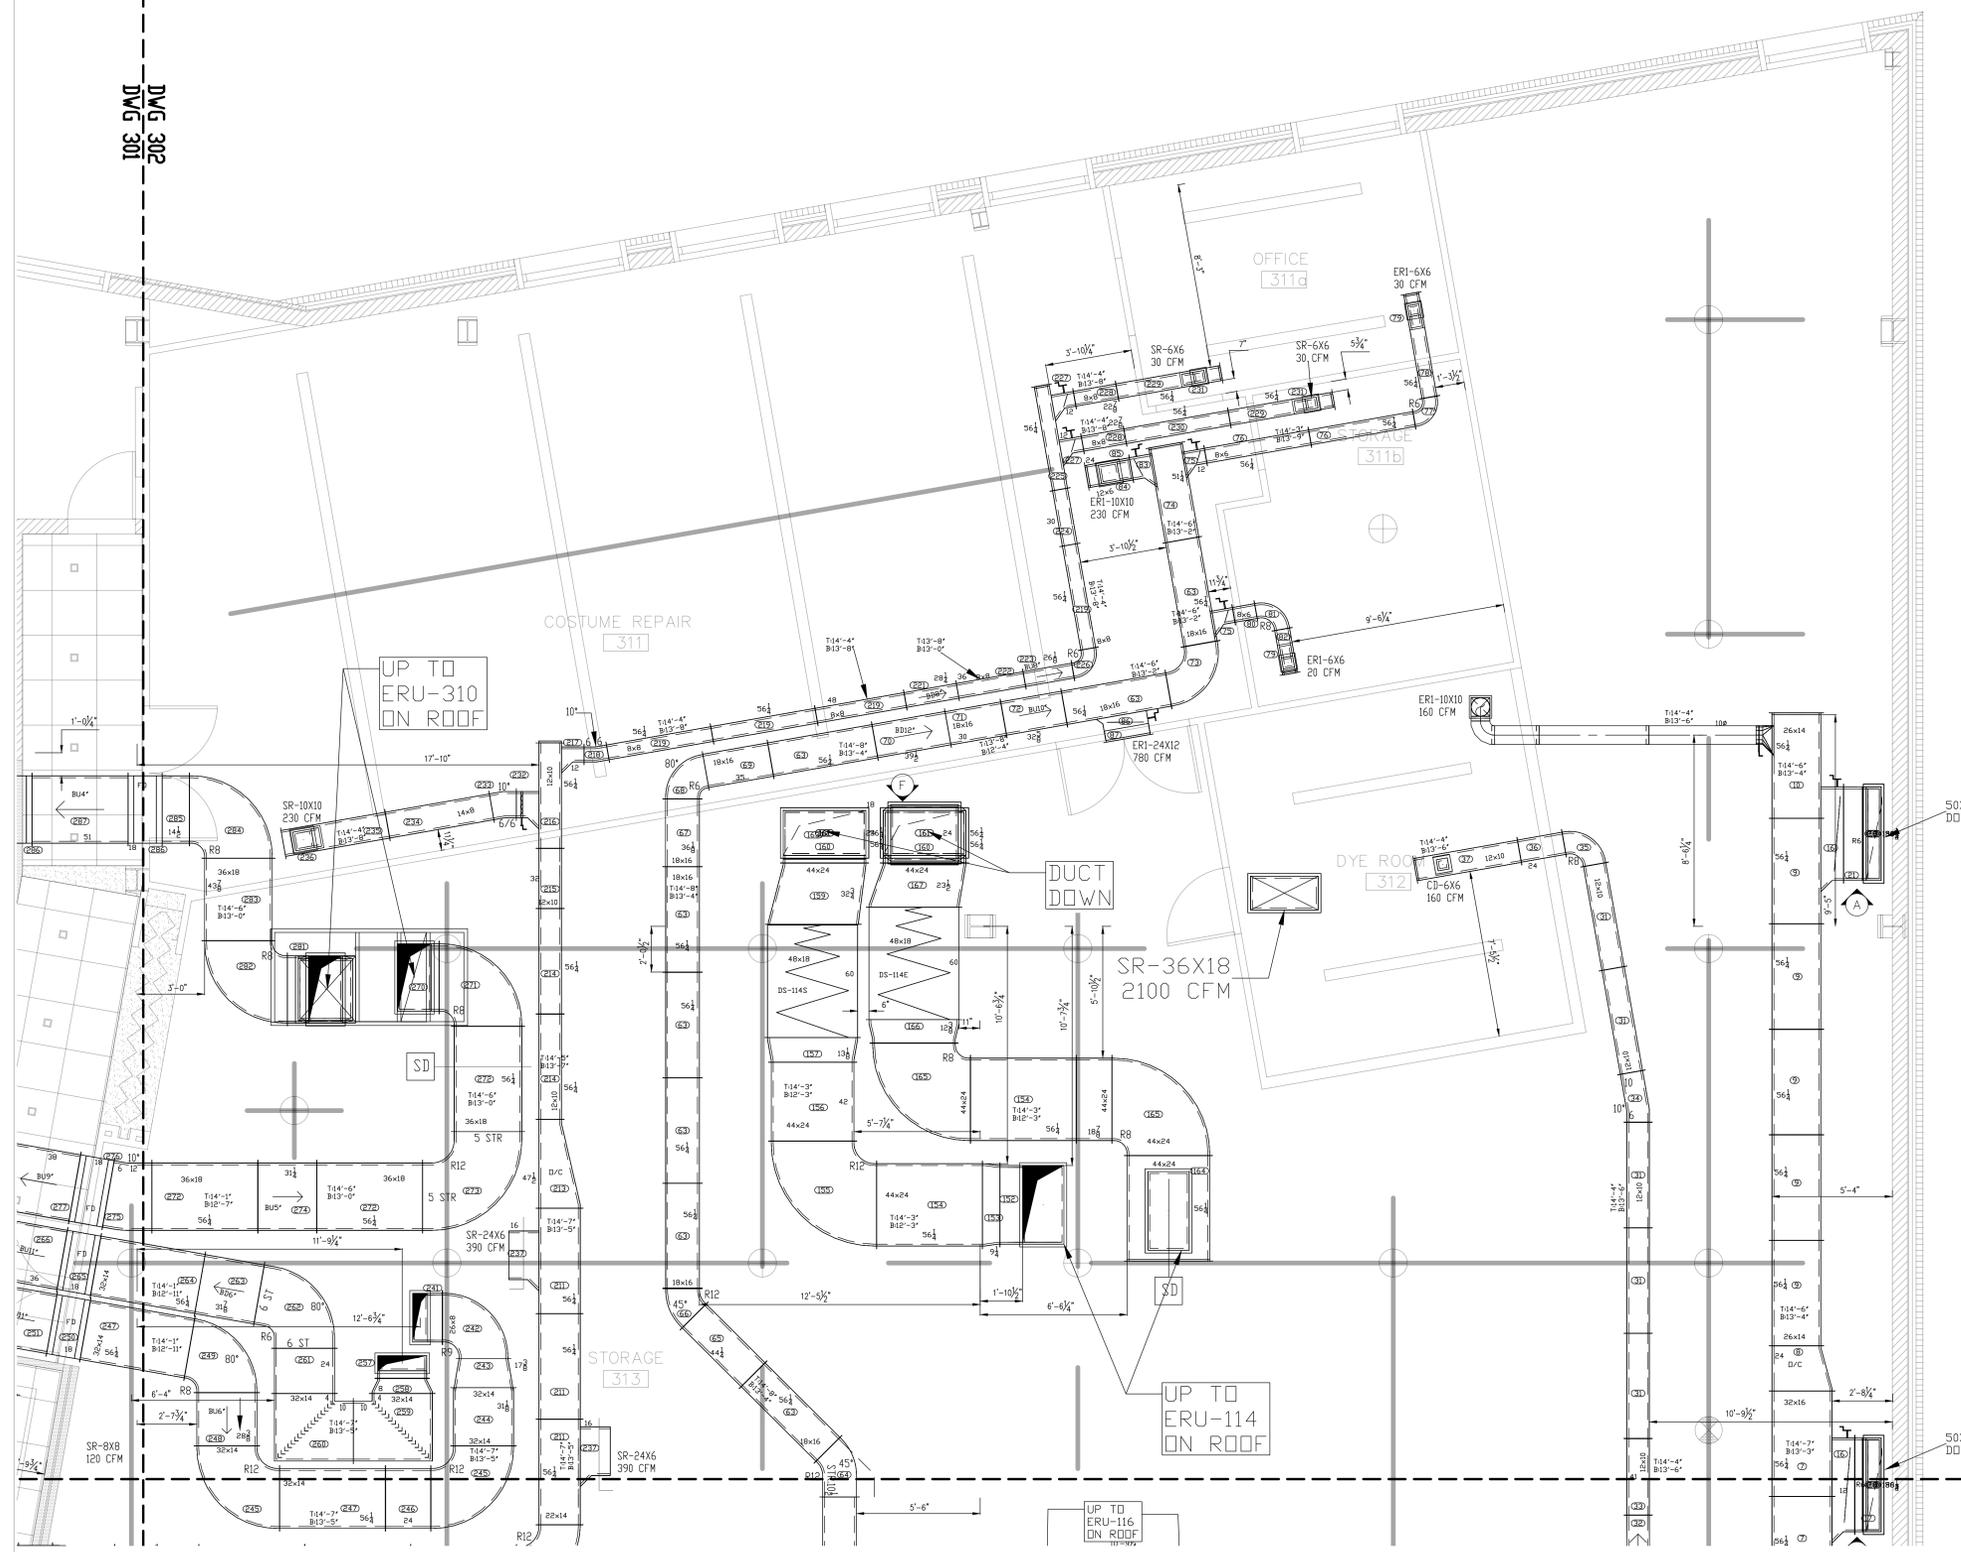

AS BUILT
11-5-2019

AS BUILT	11/5/19
No. REVISION	DATE
RICHARD SHEET METAL, INC.	
COMMERCIAL & INDUSTRIAL CONTRACTOR 93 HARRISON STREET PATERTSON, NJ 07501	
PHONE# (862) 239-1820	FAX# (862) 239-1821
TWO RIVER THEATER COMPANY NEW BUILDING	
LOCATION: 21 BRIDGE AVE., RED BANK, NEW JERSEY	
TITLE: 3RD FLOOR DUCT LAYOUT HVAC PLAN	
DRAWN BY: CHARLES C.	DATE: 8/21/18
SCALE: 3/8" = 1'-0"	MECH. DWG: M2.2
PROJECT: DWG No.	
CHK'D BY: RL	RSM-1224-302

DWG 302
DWG 304